



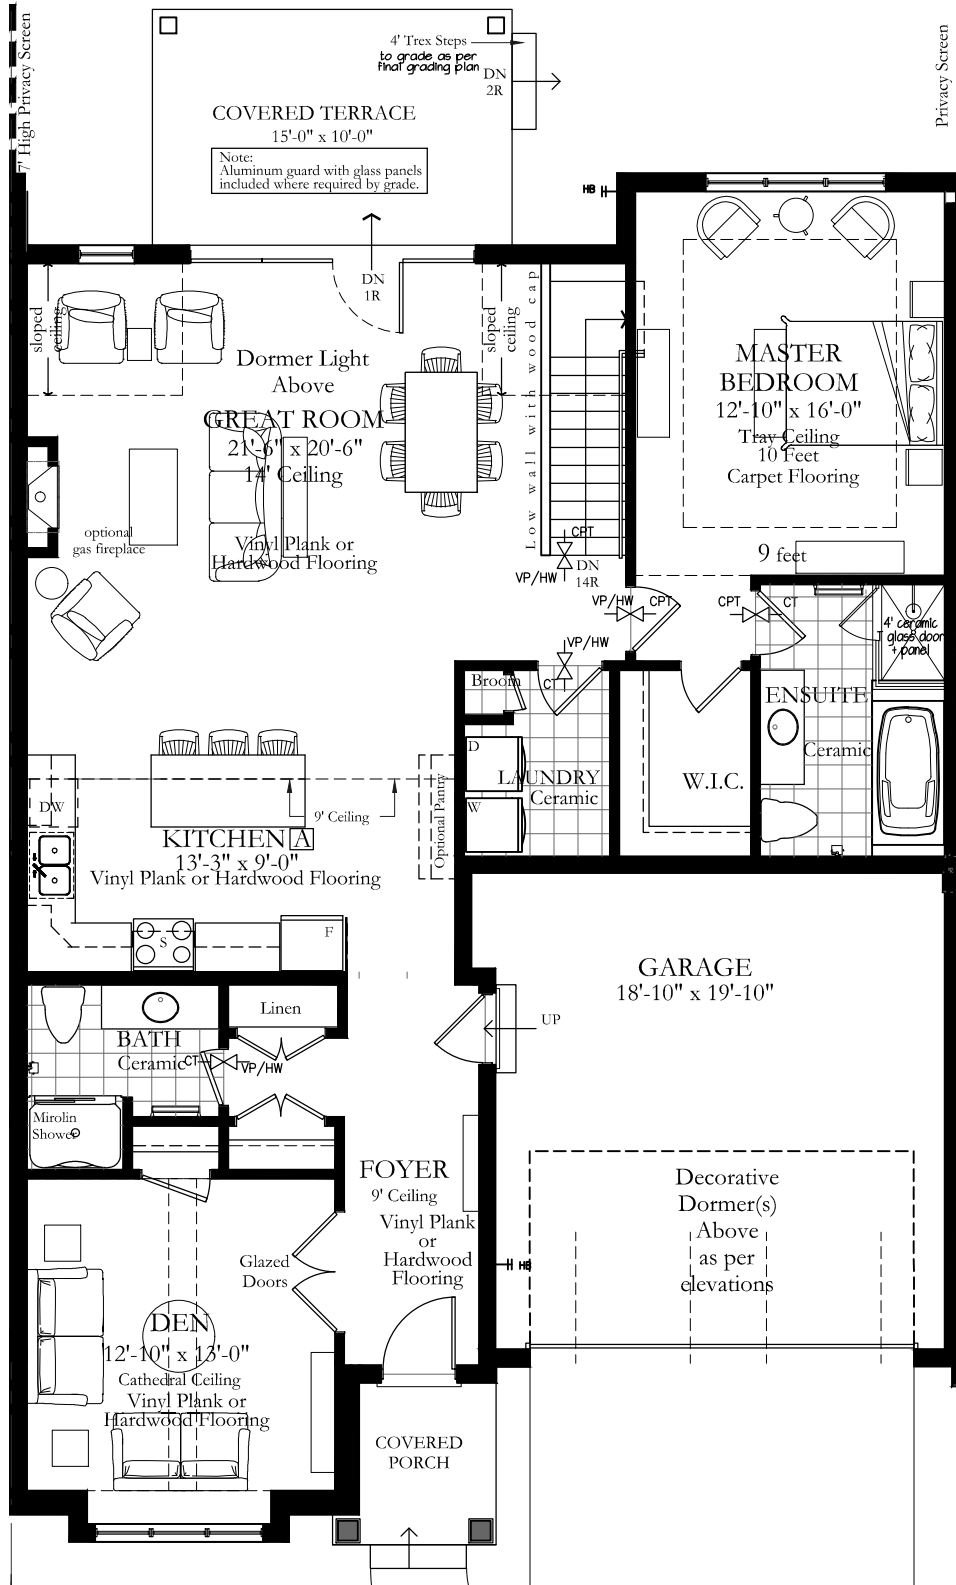

Linden
Main Floor Plan
1552 Square Feet
scale: 1/8"=1'-0"



ELECTRICAL LEGEND				NOTES:				MECHANICAL LEGEND					
	RECESSED INTERIOR DOWNLIGHT		VAPOUR PROOF SURFACE MOUNTED CEILING INCANDESCENT FIXTURE		UNDERCOUNTER FLOURESCENT		DOOR ACTIVATED LIGHT		BOX FOR FUTURE VEHICLE CHARGING		TELEPHONE		HOSE BIB (FROST PROOF)
	RECESSED INTERIOR DOWNLIGHT -VAPOUR PROOF		RECESSED JUNCTION BOX		EXTERIOR FLOOD LIGHT U/SOF ROOF OVERHANG W/MOTION SENSOR		110V DUPLEX OUTLET		SMOKE/CARBON MONOXIDE DETECTOR		CABLE		ENERGY RECOVERY VENTILATOR
	RECESSED EXTERIOR DOWNLIGHT		EXTERIOR WALL MOUNTED INCANDESCENT FIXTURE		OVERHEAD GARAGE DOOR OPERATOR c/w LIGHT SWITCH		220V APPLIANCE		EXHAUST FAN		WHIRLPOOL MOTOR		THERMOSTAT
	SURFACE MOUNTED CEILING INCANDESCENT FIXTURE, RECESSED JUNCTION BOX		INTERIOR WALL MOUNTED INCANDESCENT FIXTURE		SWITCH-FIREPLACE		BATHROOM GROUND FAULT OUTLET		CHIME		CEILING FAN		FIREPLACE THERMOSTAT
	INCANDESCENT FIXTURE, WITH PULL CHAIN		INTERIOR WALL MOUNTED INCANDESCENT FIXTURE 2 LIGHTS		3 WAY SWITCH		COUNTER HEIGHT GROUND FAULT OUTLET		RECESSED CEILING SPEAKER				EXHAUST FAN
	TRACK LIGHT		INTERIOR WALL MOUNTED INCANDESCENT FIXTURE 3 LIGHTS		DIMMER SWITCH		FLOOR OUTLET		CENTRAL VACUUM OUTLET				
			OPTIONAL RECESSED DOWNLIGHTS WITH DIMMER SWITCH										

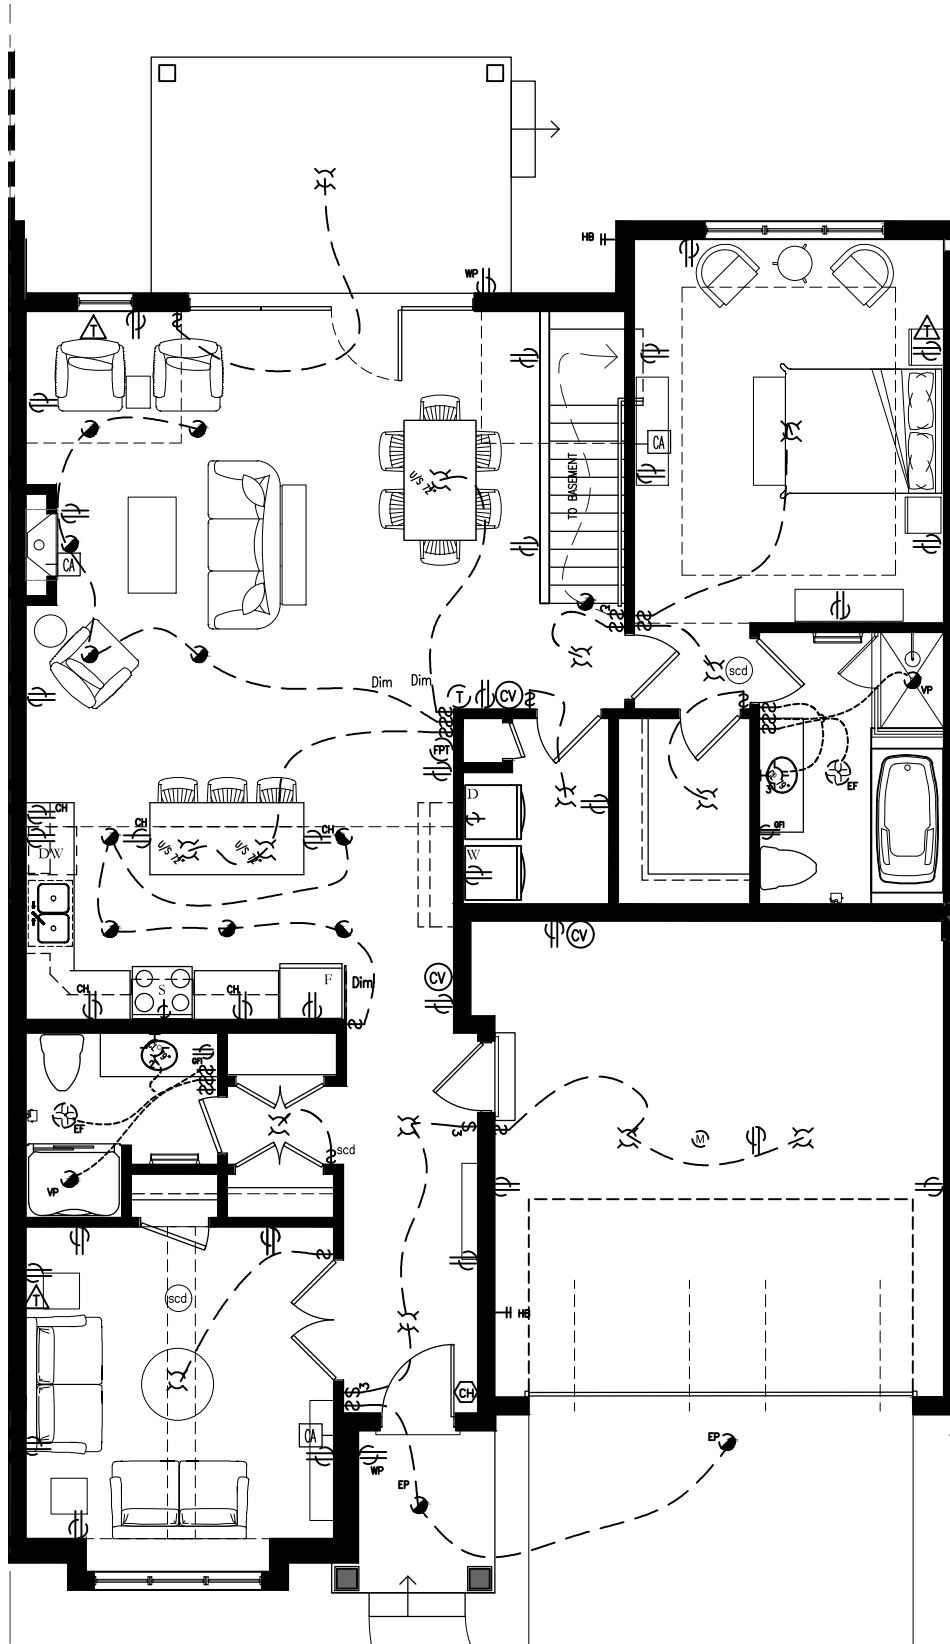


Linden
Main Floor Plan
Electrical Concept Plan
Actual may vary.
scale: 1/8"=1'-0"





ELECTRICAL LEGEND				NOTES:		MECHANICAL LEGEND							
	RECESSED INTERIOR DOWNLIGHT		VAPOUR PROOF SURFACE MOUNTED CEILING INCANDESCENT FIXTURE		UNDERCOUNTER FLOURESCENT		\$DAL DOOR ACTIVATED LIGHT		BOX FOR FUTURE VEHICLE CHARGING		TELEPHONE		HOSE BIB (FROST PROOF)
	RECESSED INTERIOR DOWNLIGHT -VAPOUR PROOF		RECESSED JUNCTION BOX		EXTERIOR FLOOD LIGHT		110V DUPLEX OUTLET		SMOKE/CARBON MONOXIDE DETECTOR		CABLE		ENERGY RECOVERY VENTILATOR
	RECESSED EXTERIOR DOWNLIGHT		EXTERIOR WALL MOUNTED INCANDESCENT FIXTURE		OVERHEAD GARAGE DOOR OPERATOR c/w LIGHT SWITCH		220V APPLIANCE		EXHAUST FAN		WHIRLPOOL MOTOR		THERMOSTAT
	SURFACE MOUNTED CEILING INCANDESCENT FIXTURE, RECESSED JUNCTION BOX		INTERIOR WALL MOUNTED INCANDESCENT FIXTURE		SWITCH-FIREPLACE		BATHROOM GROUND FAULT OUTLET		CHIME		CEILING FAN		FIREPLACE THERMOSTAT
	INCANDESCENT FIXTURE, WITH PULL CHAIN		INTERIOR WALL MOUNTED INCANDESCENT FIXTURE 2 LIGHTS		3 WAY SWITCH		COUNTER HEIGHT GROUND FAULT OUTLET		RECESSED CEILING SPEAKER				EXHAUST FAN
	TRACK LIGHT		INTERIOR WALL MOUNTED INCANDESCENT FIXTURE 3 LIGHTS		DIMMER SWITCH		FLOOR OUTLET		CENTRAL VACUUM OUTLET				
			OPTIONAL RECESSED DOWNLIGHTS WITH DIMMER SWITCH										

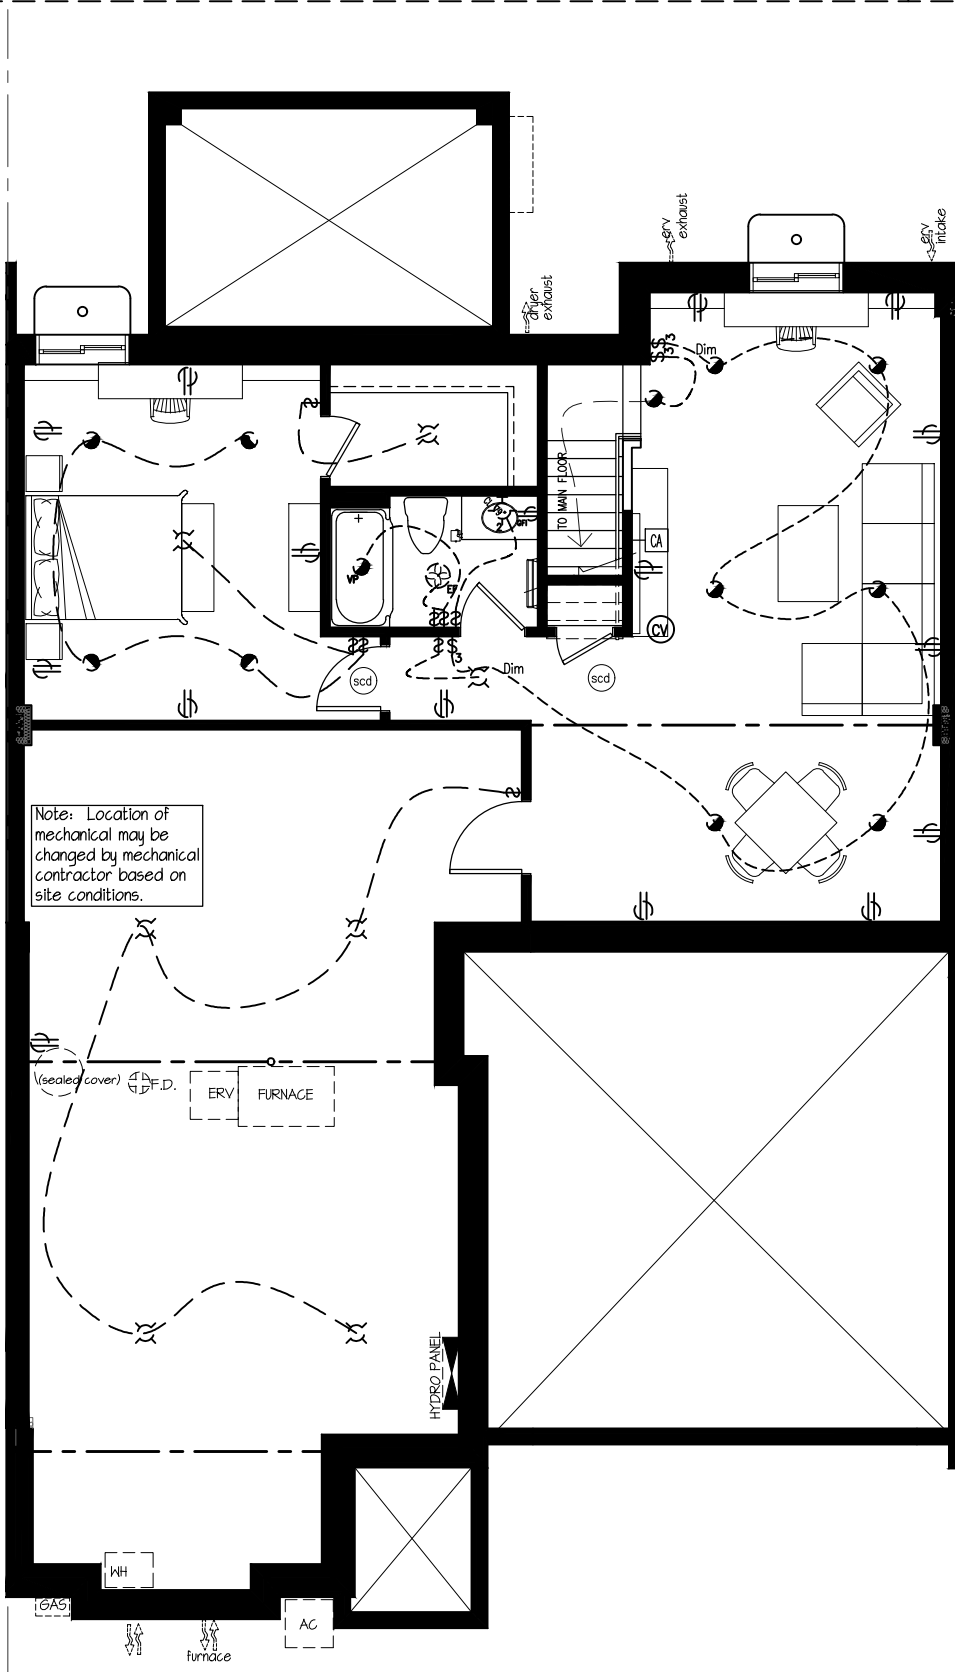


Linden
Optional
Basement Floor Plan
Electrical Concept Plan
Actual may vary.
scale: 1/8"=1'-0"





Linden
Front Elevation
scale: $\frac{1}{8}"=1'-0"$



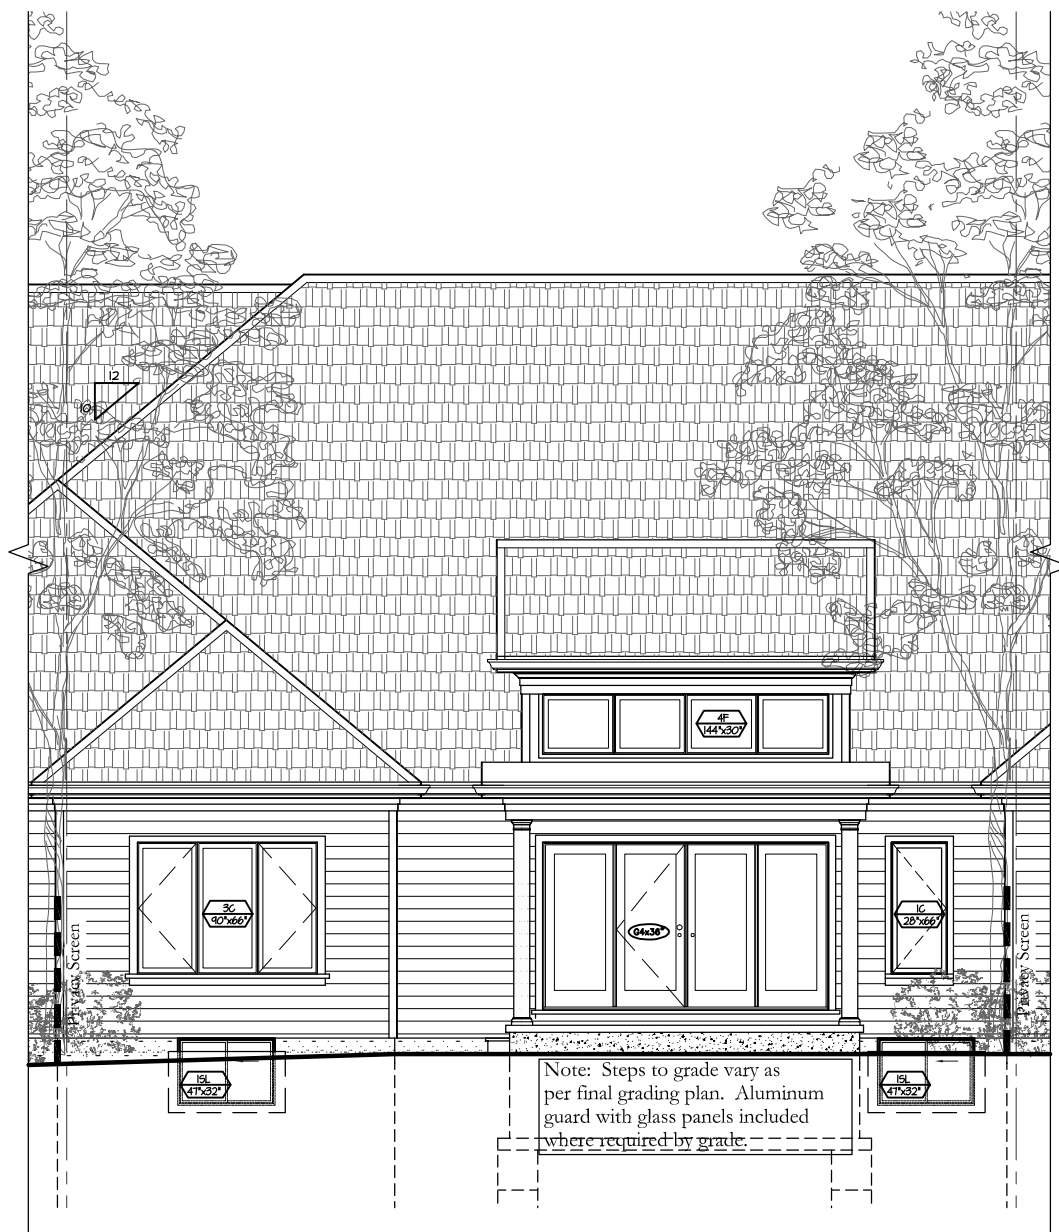

Linden
Rear Elevation
scale: $\frac{1}{8}"=1'-0"$

